

NKBA STUDENT COMPETITION 2021

CONCEPT STATEMENT:

EXPANDING THE HORIZON

CONCEPT:

DEEPA LAGHARI, OWEN MILLER, AND THEIR DAUGHTER PRIYA REQUESTED A RENOVATION FOR THEIR BORING KITCHEN THEY BOUGHT A YEAR AGO. USING INSPIRATION FROM THEIR LOVE OF THE ENVIRONMENT, A SUSTAINABLE KITCHEN WAS DESIGNED FOR THEM TO BRING THE OUTDOORS IN. THE WALLS WERE TRANSFORMED FROM BEING A BOXY CAGE WITH LIMITED LIGHTING INTO A OASIS THAT MAKES THE OUTDOORS IT'S FEATURE. BY OPENING THE PLAN NORTH WALL WITH STACKING EXPANDABLE GLASS WINDOWS AND DOORS, THIS IS THE PRIMARY FOCAL POINT OF THE KITCHEN. WITH NEW FINISHES, INCLUDING A CATHEDRAL CEILING WITH WOOD BEAMS, LEATHER DRAWER PULLS, AND EARTH TONES, THIS COMFORTING KITCHEN WILL BE A PLACE EVERYONE WILL WANT TO STAY IN. A LARGER PANTRY KEEPS ALL MEMBERS OF THE FAMILY HAPPY WITH SNACKS, AND THE EXTENDED COUNTERTOP PAST THE WINDOW WALL MAKES GRILL NIGHT AN EASY NIGHT WITH LESS HASSLE. LASTLY, TO INCORPORATE DEEPA'S LOVE OF BOHEMIAN STYLE AND TO CELEBRATE HER INDIAN HERITAGE, A DECORATIVE BACKSPLASH CAN BE SEEN THROUGHOUT THE SPACE TO ADD A BIT OF BRIGHT FUN. OVERALL, EVEN FROM THE DINING ROOM, ONE CAN'T HELP BUT NOTICE THE EARTHY AMBIENCE OF THE KITCHEN, AND WITH THE EXPANDING WINDOW WALL GIVING A VIEW TO THE BACKYARD AND BEYOND, MANY EVENINGS WILL BE ENJOYED BY VIEWING THE HORIZON.

TABLE OF CONTENTS:

CS COVERSHEET
AOI SCHEDULES-APPLIANCE AND PLUMBING
AI FLOOR PLAN
A2 MECHANICAL ENGINEERING PLAN, RCP
A3 NORTH ELEVATION
A4 EAST AND WEST ELEVATION
A5 PANTRY EAST, PANTRY SOUTH, AND ISLAND
ELEVATION

PERSPECTIVE

PERSPECTIVE 2

PROJECT OVERVIEW PAGE WITH INSPIRATION, CONCEPT, AND MATERIALS

ALL DIMENSIONS AND SIZE
DESIGNATIONS GIVEN ARE
SUBJECT TO VERIFICATION
ON JOB SITE & ADJUSTMENT
TO FIT FIT JOB CONDITIONS



DESIGN PLANS ARE PROVIDED FOR THE FAIR USE BY THE CLIENT OR HIS AGENT IN COMPLETING THE PROJECT AS LISTED WITHIN THIS CONTRACT. DESIGN PLANS REMAIN THE PROPERTY OF THIS FIRM AND CAN NOT BE USED OR REUSED WITHOUT PERMISSION.

DESIGNED FOR NKBA COMPETITION

BY
K405655591

APPLIANCE SCHEDULE

ITEM	MANUFACTURER	MODEL #	VOLTAGE	WIDTH	FINISH	FUEL	NOTES
NATURAL GAS COOKTOP	MONOGRAM	ZGU30RSLS	120 V	30"	STAINLESS STEEL	GAS	DEEP RECESSED
VENT HOOD	HOODSLY	3036	600 CFM	2'-6"	WHITE/WALNUT BAND	ELECTRIC	VENTED OUT SIDE WALL
MICROWAVE OVEN	MONOGRAM	ZSB9232NSS	240 V	30"	STAINLESS STEEL	ELECTRIC	17" AFF, SMART TECHNOLOGY
REFRIGERATOR COLUMN	MIELE	K 2602 VI	120 V	23-3/4"	PANEL READY	ELECTRIC	WORKS W/ APP
FREEZER COLUMN	MIELE	FNS 37492 IE	115 V	22-1/8"	PANEL READY	ELECTRIC	
DOUBLE OVENS	MONOGRAM	ZTDX1DPSNS	240 V	29-3/4"	STAINLESS STEEL	ELECTRIC	SMART OVEN
DISHWASHER	MIELE	G 7566 SCV SF AUTODOS	120 V	23-5/8"	STAINLESS STEEL	ELECTRIC	

APPLIANCE SCHEDULE

SCALE: N/A

PLUMBING SCHEDULE

ITEM	MANUFACTURER	MODEL #	FINISH	NOTES
UNDERMOUNT SINK	BRIZO	64965LF-MWLHP, HLK177-MWWD	WHITE W/ WOOD HANDLE	JASON WU FOR BRIZO SMART TOUCH
FAUCET	MOEN	FC301810	WHITE FIRECLAY	

② PLUMBING FIXTURES SCHEDULE

SCALE: N/A

ALL DIMENSIONS AND SIZE
DESIGNATIONS GIVEN ARE
SUBJECT TO VERIFICATION
ON JOB SITE & ADJUSTMENT
TO FIT JOB CONDITIONS




DESIGN PLANS ARE PROVIDED FOR THE FAIR USE BY THE CLIENT OR HIS AGENT IN COMPLETING THE PROJECT AS LISTED WITHIN THIS CONTRACT. DESIGN PLANS REMAIN THE PROPERTY OF THIS FIRM AND CAN NOT BE USED OR REUSED WITHOUT PERMISSION.

DESIGNED FOR NKRA COMPETITION

BY
K4056555917

DATE	BY	SCALED	DWG NO
DWN	09022021		
REV			

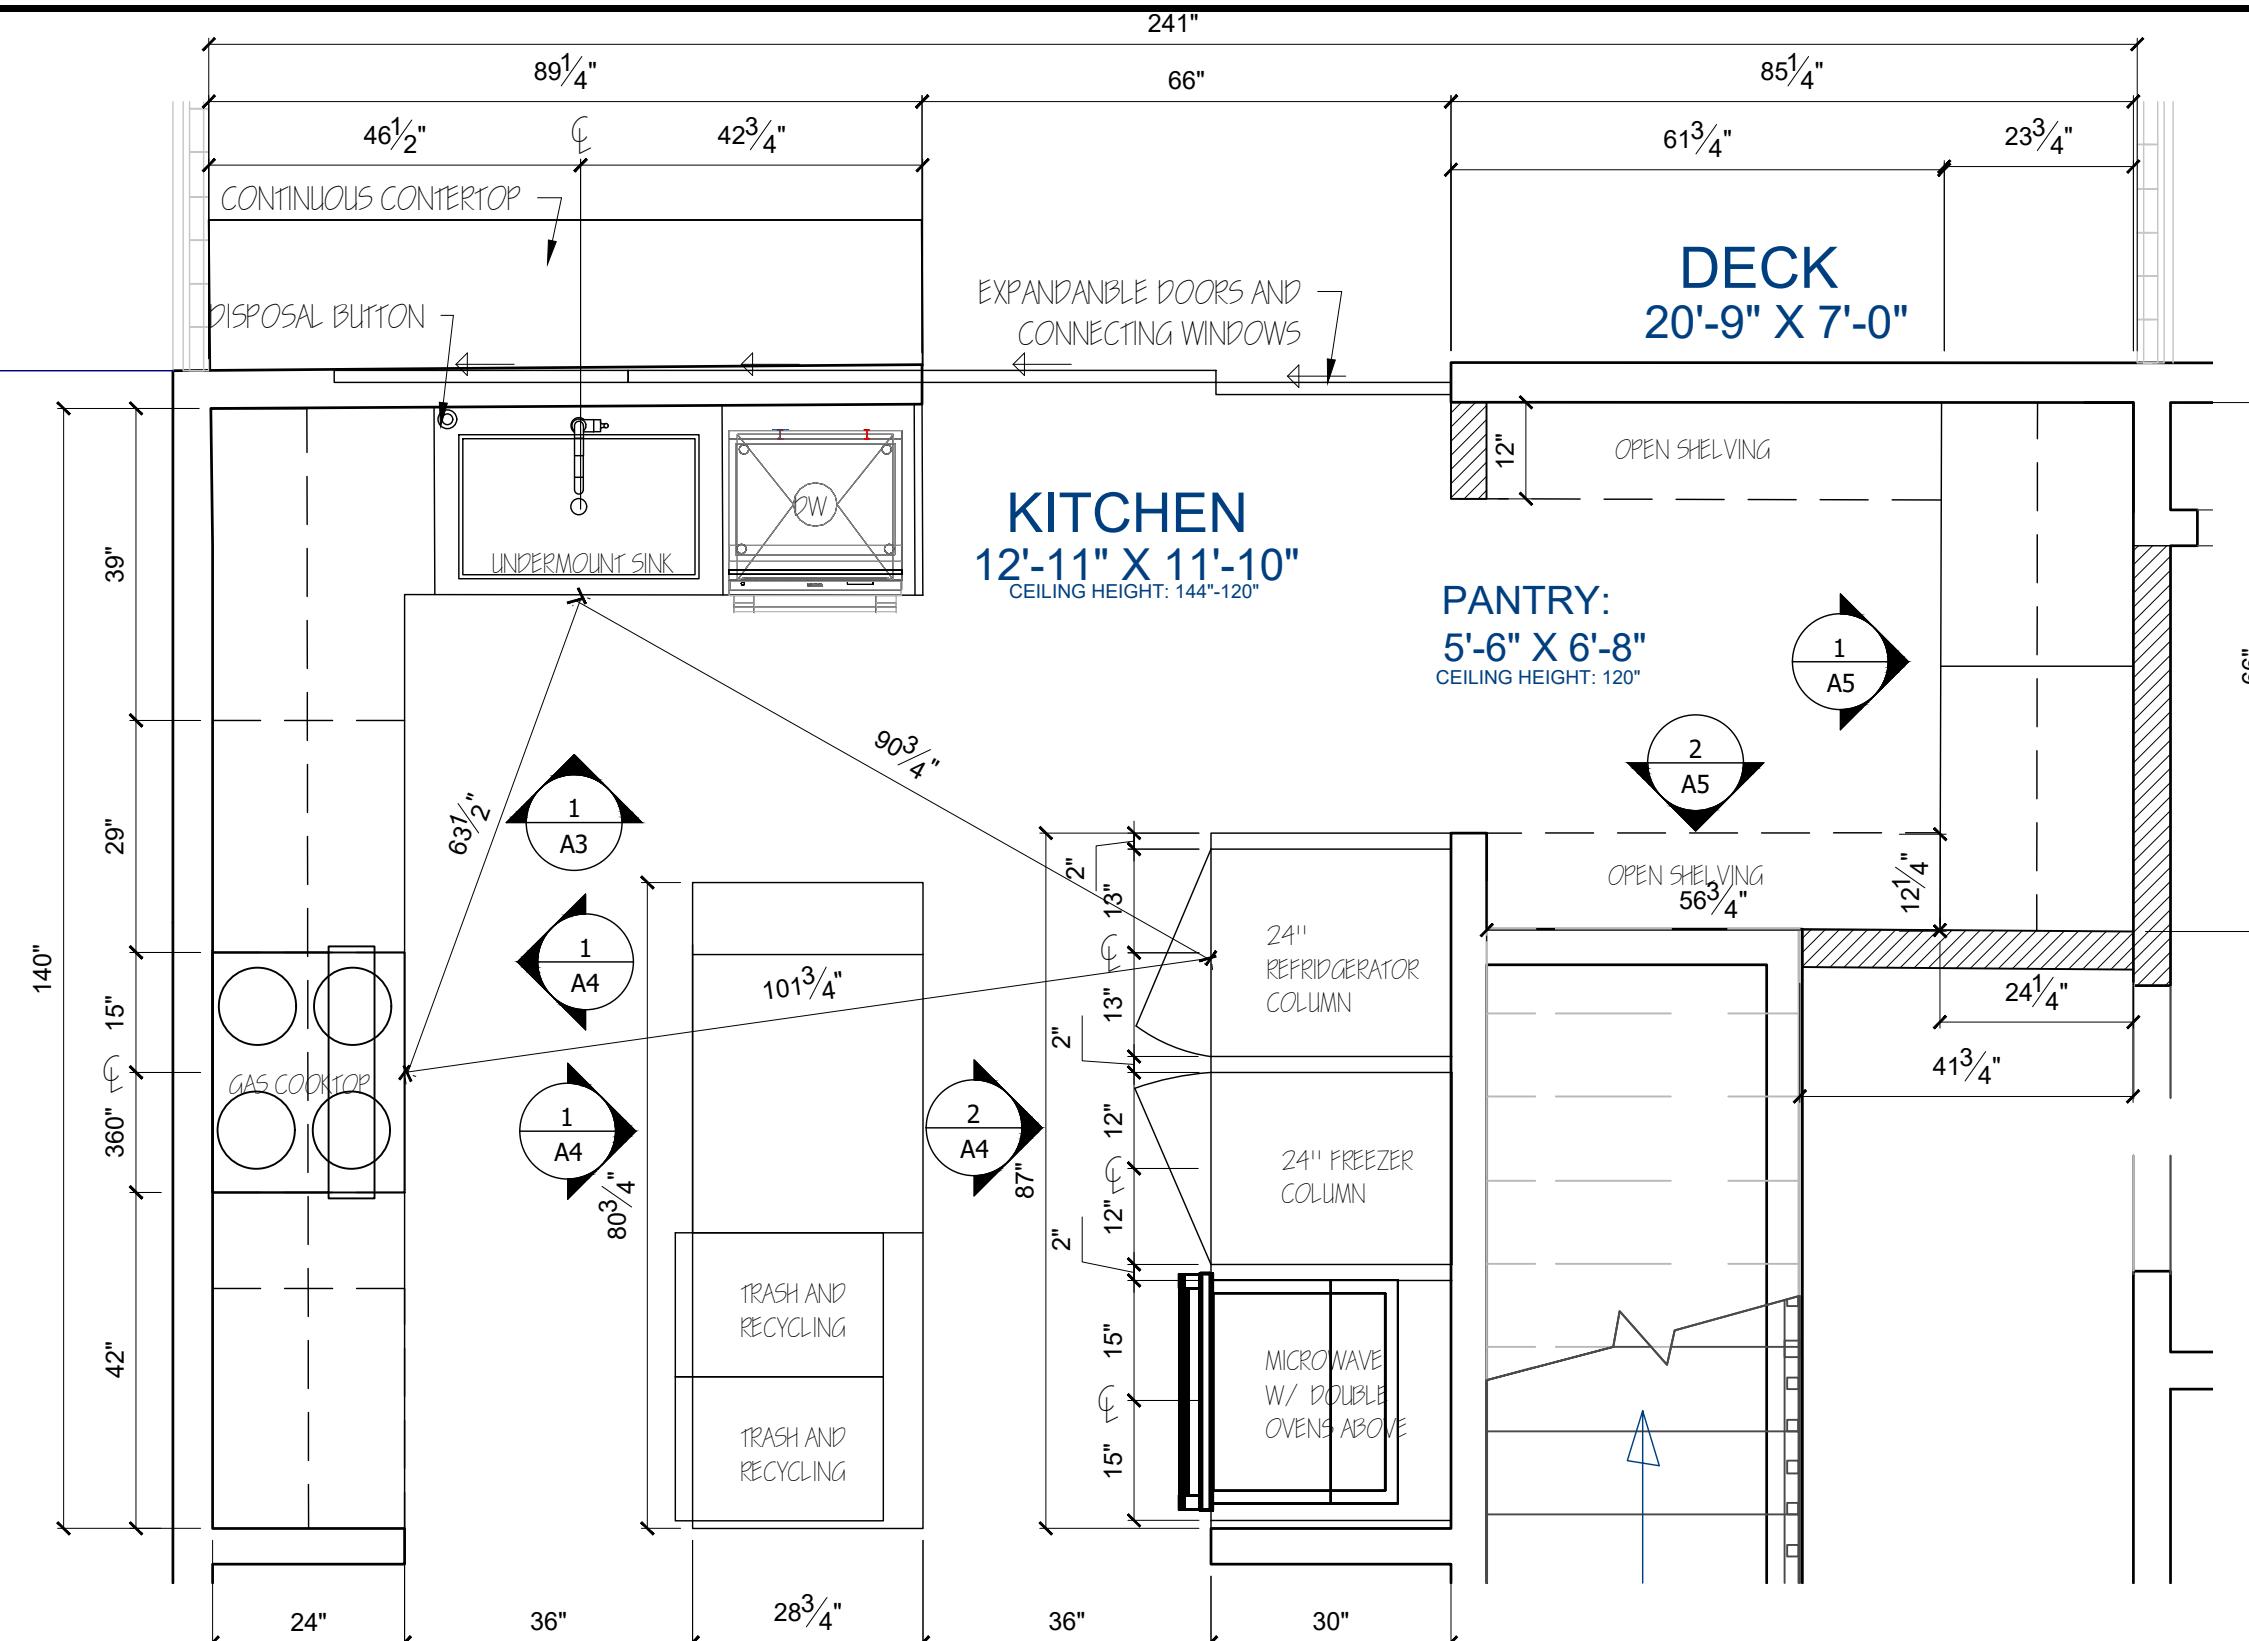

FLOOR PLAN
SCALE: 1/2" = 1'-0"

N

ALL DIMENSIONS AND SIZE DESIGNATIONS GIVEN ARE SUBJECT TO VERIFICATION ON JOB SITE & ADJUSTMENT TO FIT JOB CONDITIONS

NKBA *The Finest Professionals in the Kitchen & Bath Industry*
National Kitchen & Bath AssociationSM

DESIGN PLANS ARE PROVIDED FOR THE FAIR USE BY THE CLIENT OR HIS AGENT IN COMPLETING THE PROJECT AS LISTED WITHIN THIS CONTRACT. DESIGN PLANS REMAIN THE PROPERTY OF THIS FIRM AND CAN NOT BE USED OR REUSED WITHOUT PERMISSION.

DESIGNED FOR
NKBA COMPETITION

BY
K4056555917

DATE	BY	SCALED	DWG NO
DWN 09022021			
REV			

1/2" =
1'0"

A1

DECK
20'-9" X 7'-0"

KITCHEN
12'-11" X 11'-10"
CEILING HEIGHT: 144"-120"

PANTRY:
5'-6" X 6'-8"
CEILING HEIGHT: 120"

NOTES:

- ALL RECEPTACLES TO BE AFCI.
- REFER TO APPLIANCE SCHEDULE ON AOI FOR MORE INFORMATION.
- CEILING TO BE PAINTED SHERWIN WILLIAMS "EXTRA WHITE".
- SWITCHES TO BE INSTALLED AT 42" AFF (CENTERLINE) UNLESS OTHERWISE SPECIFIED.
- OUTLETS INSTALLED AT 38" AFF (CENTERLINE) UNLESS OTHERWISE SPECIFIED.
- SEE ELEVATIONS FOR EXACT OUTLET PLACEMENTS.

MECHANICAL LEGEND

- ∅ ARC-FAULT CIRCUIT INTERRUPTER 38" AFF UNLESS OTHERWISE NOTED
- ONE WAY LIGHT SWITCH
- THREE WAY LIGHT SWITCH
- ▷ MW MICROWAVE, MONOGRAM, ZSB9232N5S, 240V, 29" AFF
- ▷ DW DO DISPOSAL, MOEN, AX100C, 115V, 24" AFF
- ▷ CT GAS COOKTOP, MONOGRAM, ZGB9232N5S, 120V, 30" AFF
- ▷ HO HOOD, COPPER SINKS ONLINE, CHOOIO, 120V, 96" AFF
- ▷ OV DOUBLE OVENS, MONOGRAM, ZTDX1PSSN5S, 240V, 65" AFF
- ∅ REF REFRIGERATOR, MIELE, K2602 VI, 120V, 6" AFF
- ∅ FRZ FREEZER, MIELE, FN537492IE, 115V, 6" AFF
- OSD SMOKE DETECTOR, NEST PROTECT, N/A, 120V
- CIRCUIT LINES
- 4" ELCO RECESSED DOWNLIGHT
- UNDER CABINET LIGHT, LUMENS.COM, UU546001, 24V
- 15" D. PENDANT: REJUVENATION FOLK ABIGAIL SOFT CONE PENDANT

MECHANICAL PLAN
SCALE: 1/2" = 1'-0"



ALL DIMENSIONS AND SIZE DESIGNATIONS GIVEN ARE SUBJECT TO VERIFICATION ON JOB SITE & ADJUSTMENT TO FIT JOB CONDITIONS

NKBA *The Finest Professionals in the Kitchen & Bath Industry*
National Kitchen & Bath AssociationSM


DESIGN PLANS ARE PROVIDED FOR THE FAIR USE BY THE CLIENT OR HIS AGENT IN COMPLETING THE PROJECT AS LISTED WITHIN THIS CONTRACT. DESIGN PLANS REMAIN THE PROPERTY OF THIS FIRM AND CAN NOT BE USED OR REUSED WITHOUT PERMISSION.

DESIGNED FOR
NKBA COMPETITION

BY
K4056555917

DATE
DWN 109022021
REV

BY
SCALE
1/2" =
1'0"
DWG NO
A2

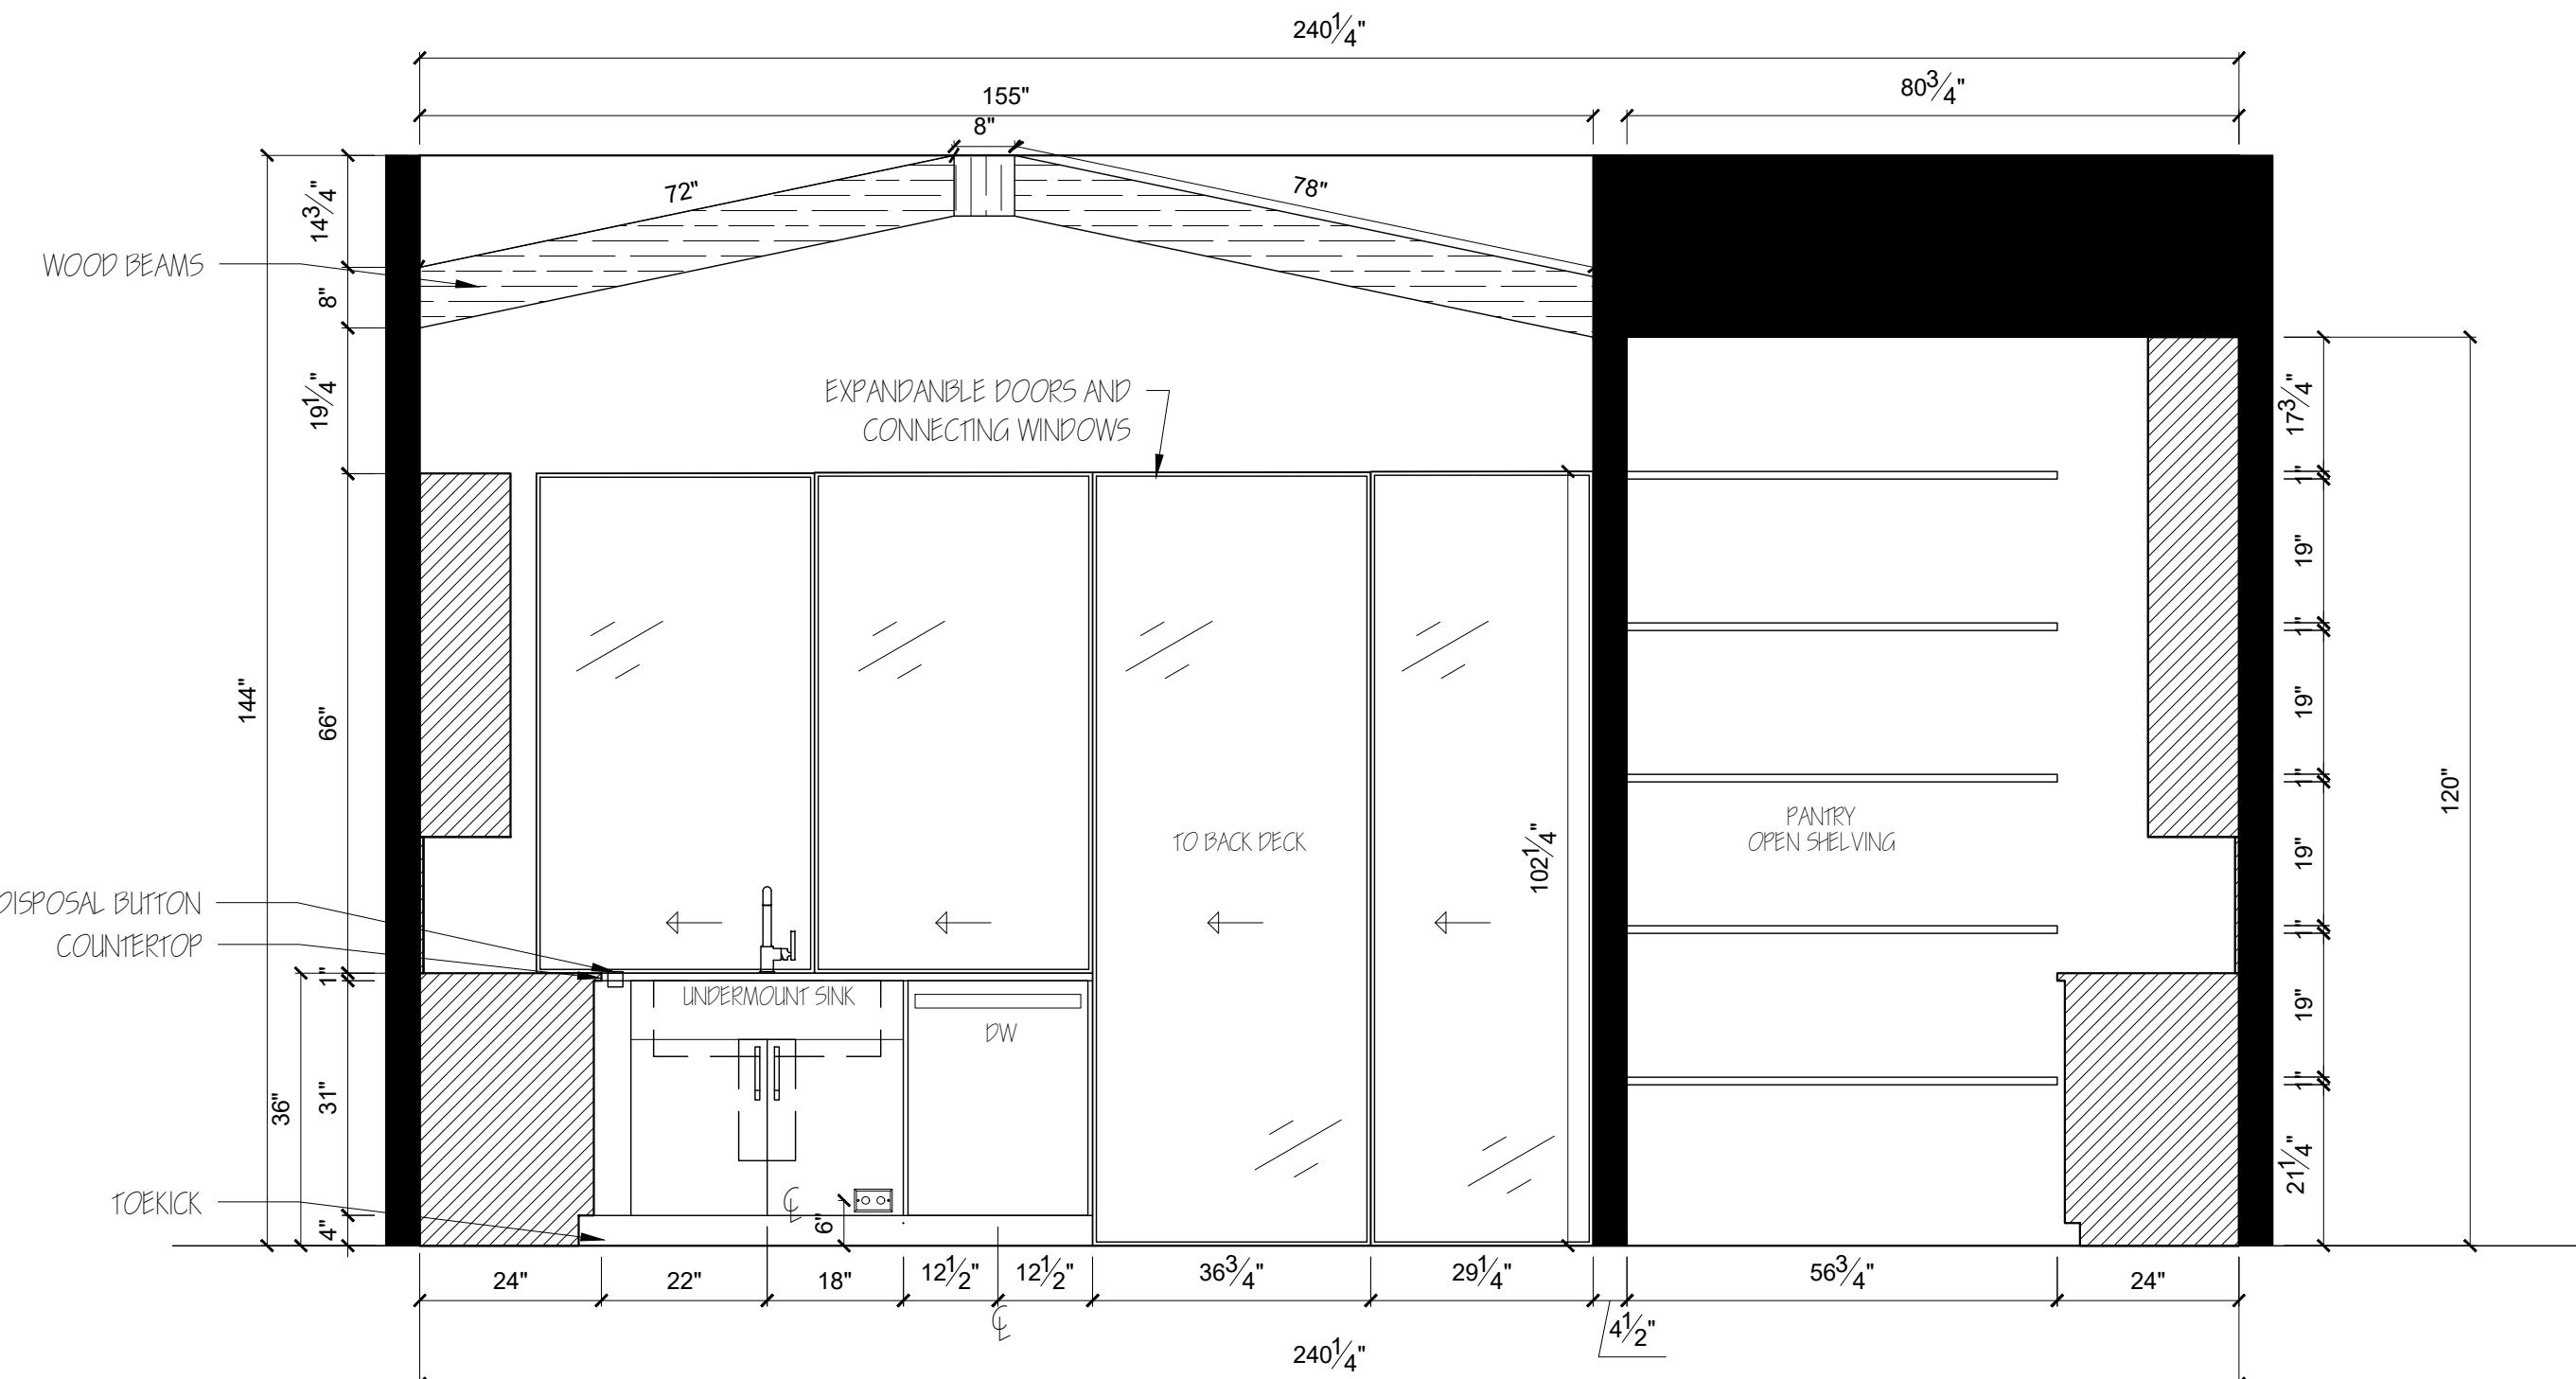

(1) NORTH ELEVATION
SCALE: 1/2" = 1'-0"

SCALE: 1/2" = 1'-0"

ALL DIMENSIONS AND SIZE
DESIGNATIONS GIVEN ARE
SUBJECT TO VERIFICATION
ON JOB SITE & ADJUSTMENT
TO FIT FIT JOB CONDITIONS




DESIGN PLANS ARE PROVIDED FOR THE FAIR USE BY THE CLIENT OR HIS AGENT IN COMPLETING THE PROJECT AS LISTED WITHIN THIS CONTRACT. DESIGN PLANS REMAIN THE PROPERTY OF THIS FIRM AND CAN NOT BE USED OR REUSED WITHOUT PERMISSION.

DESIGNED FOR NKBA COMPETITION

BY
K405655591

	DATE	BY	SCALED	DWG NO
DWN	09022021			
REV				

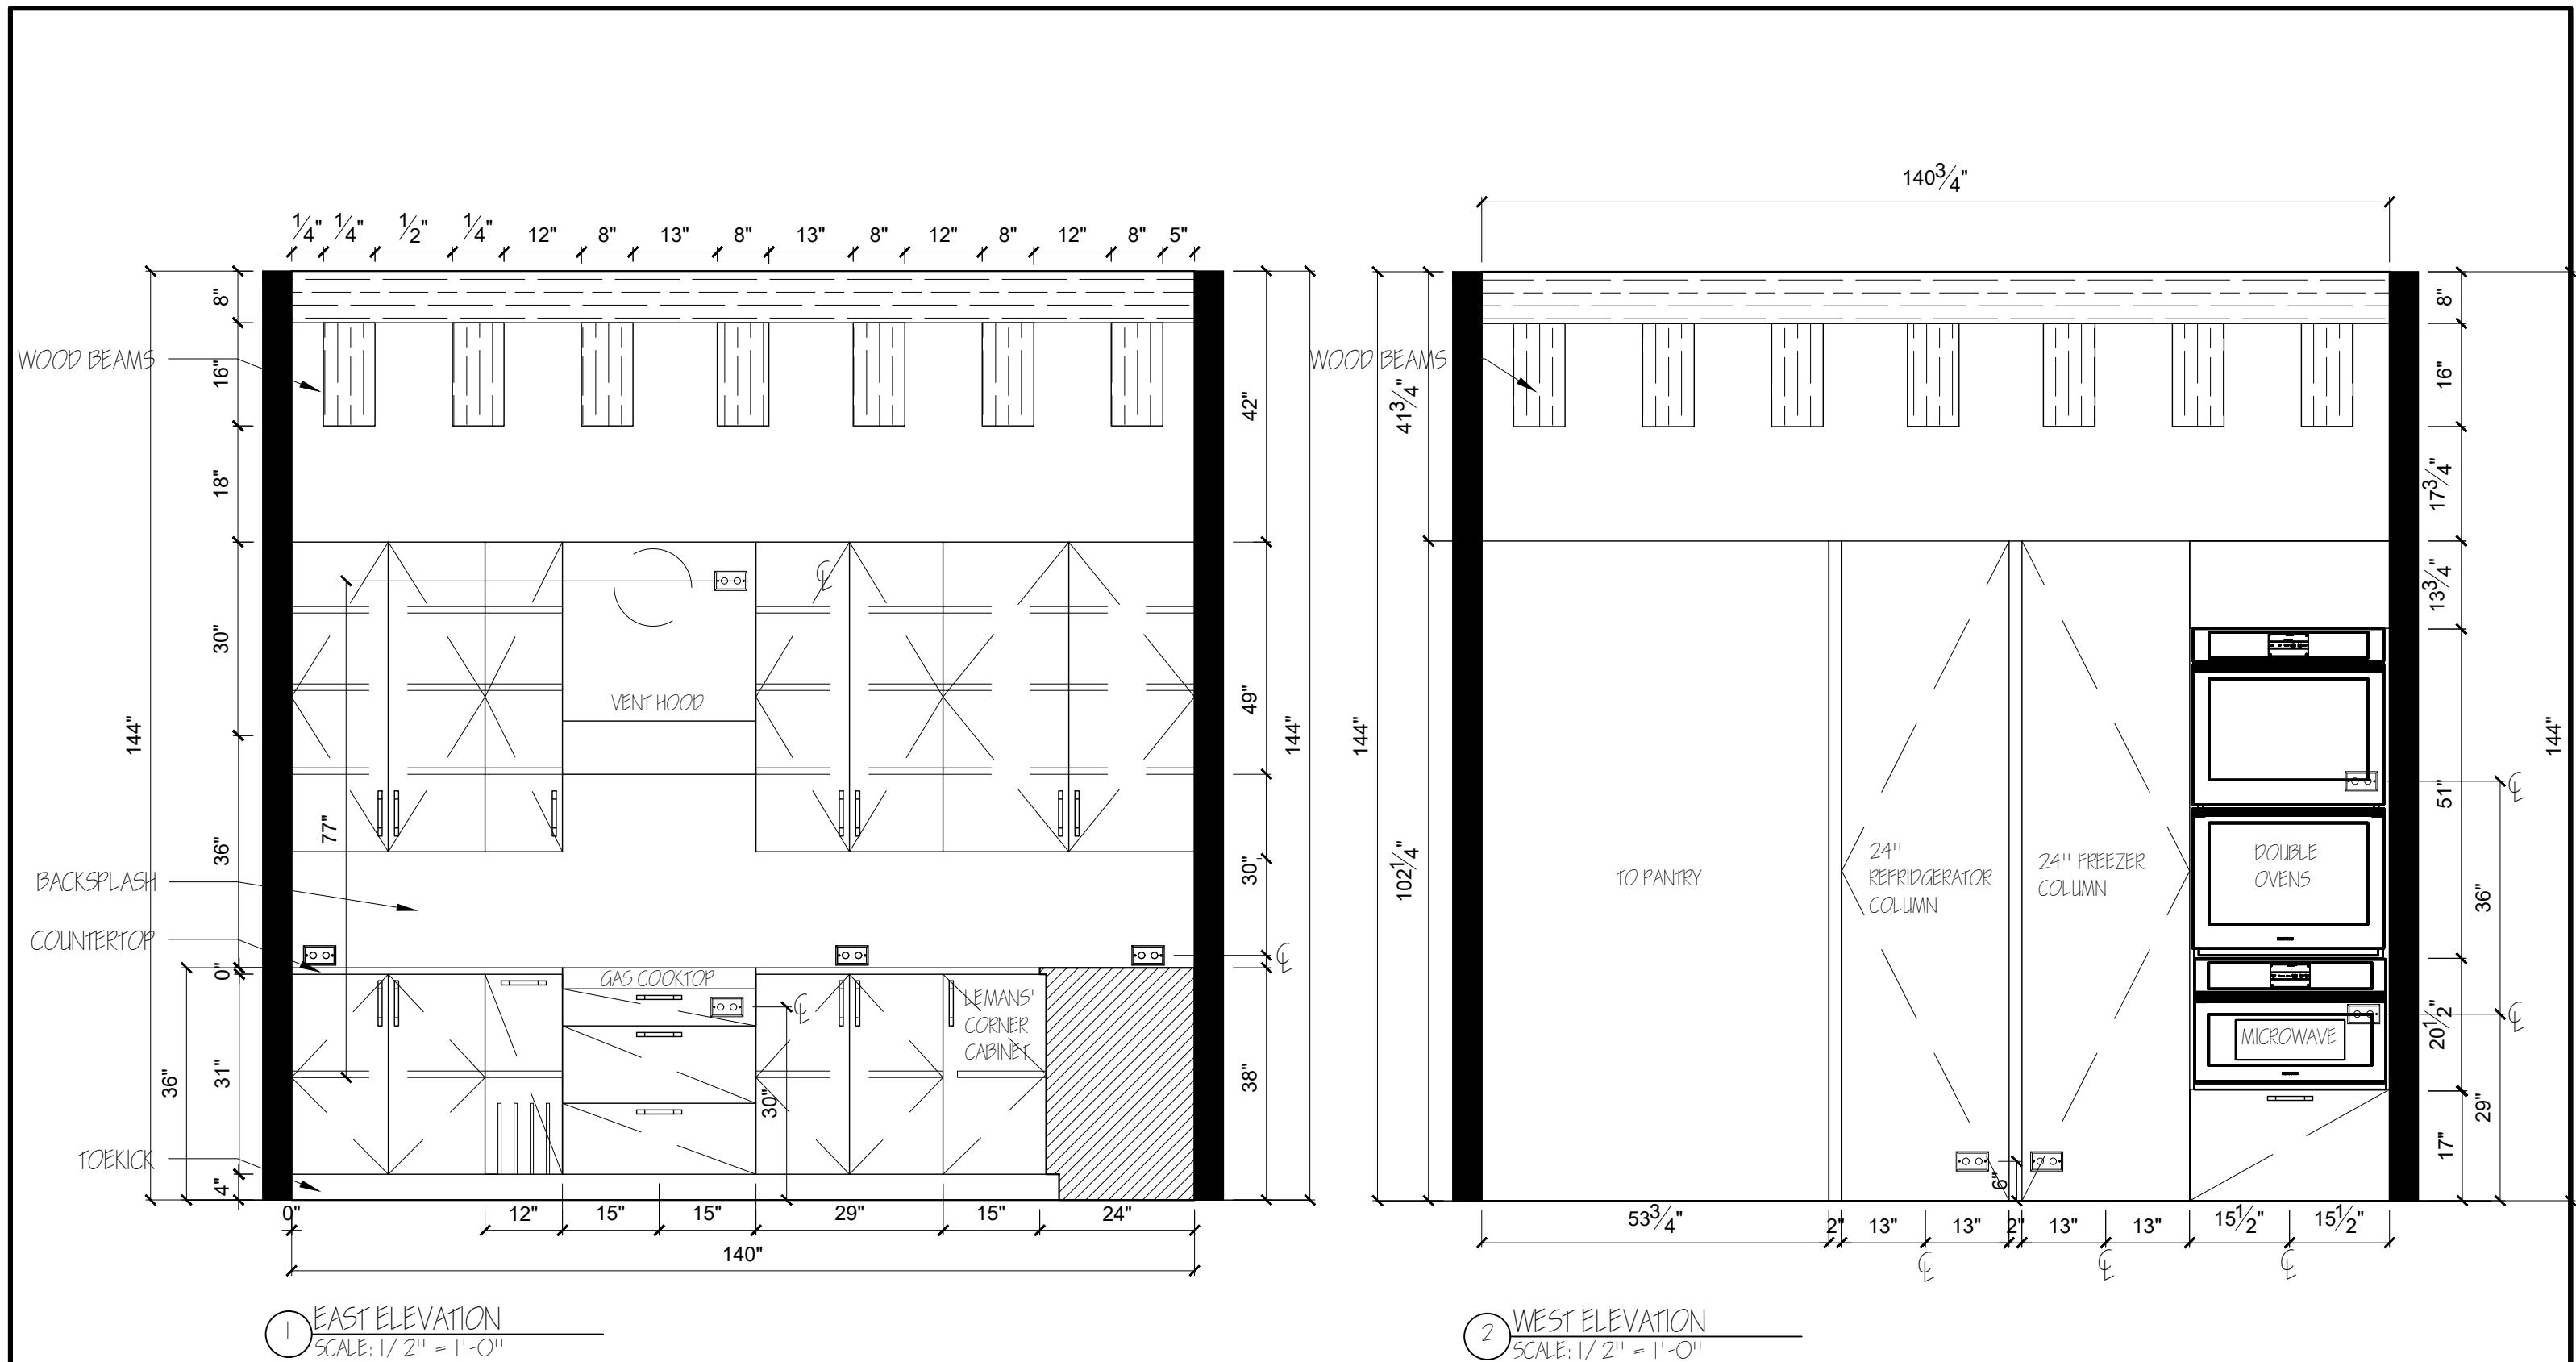

ALL DIMENSIONS AND SIZE
DESIGNATIONS GIVEN ARE
SUBJECT TO VERIFICATION
ON JOB SITE & ADJUSTMENT
TO FIT JOB CONDITIONS

NKBA *The Finest
Professionals
in the Kitchen
& Bath Industry*
National Kitchen & Bath AssociationSM


DESIGN PLANS ARE PROVIDED FOR THE FAIR USE BY THE
CLIENT OR HIS AGENT IN COMPLETING THE PROJECT AS
LISTED WITHIN THIS CONTRACT. DESIGN PLANS REMAIN
THE PROPERTY OF THIS FIRM AND CAN NOT BE USED OR
REUSED WITHOUT PERMISSION.

DESIGNED FOR
NKBA COMPETITION

BY
K4056555917

DATE
09022021
BY
DWN
REV

SCALE
1/2" =
1'0"
DWG NO
A4

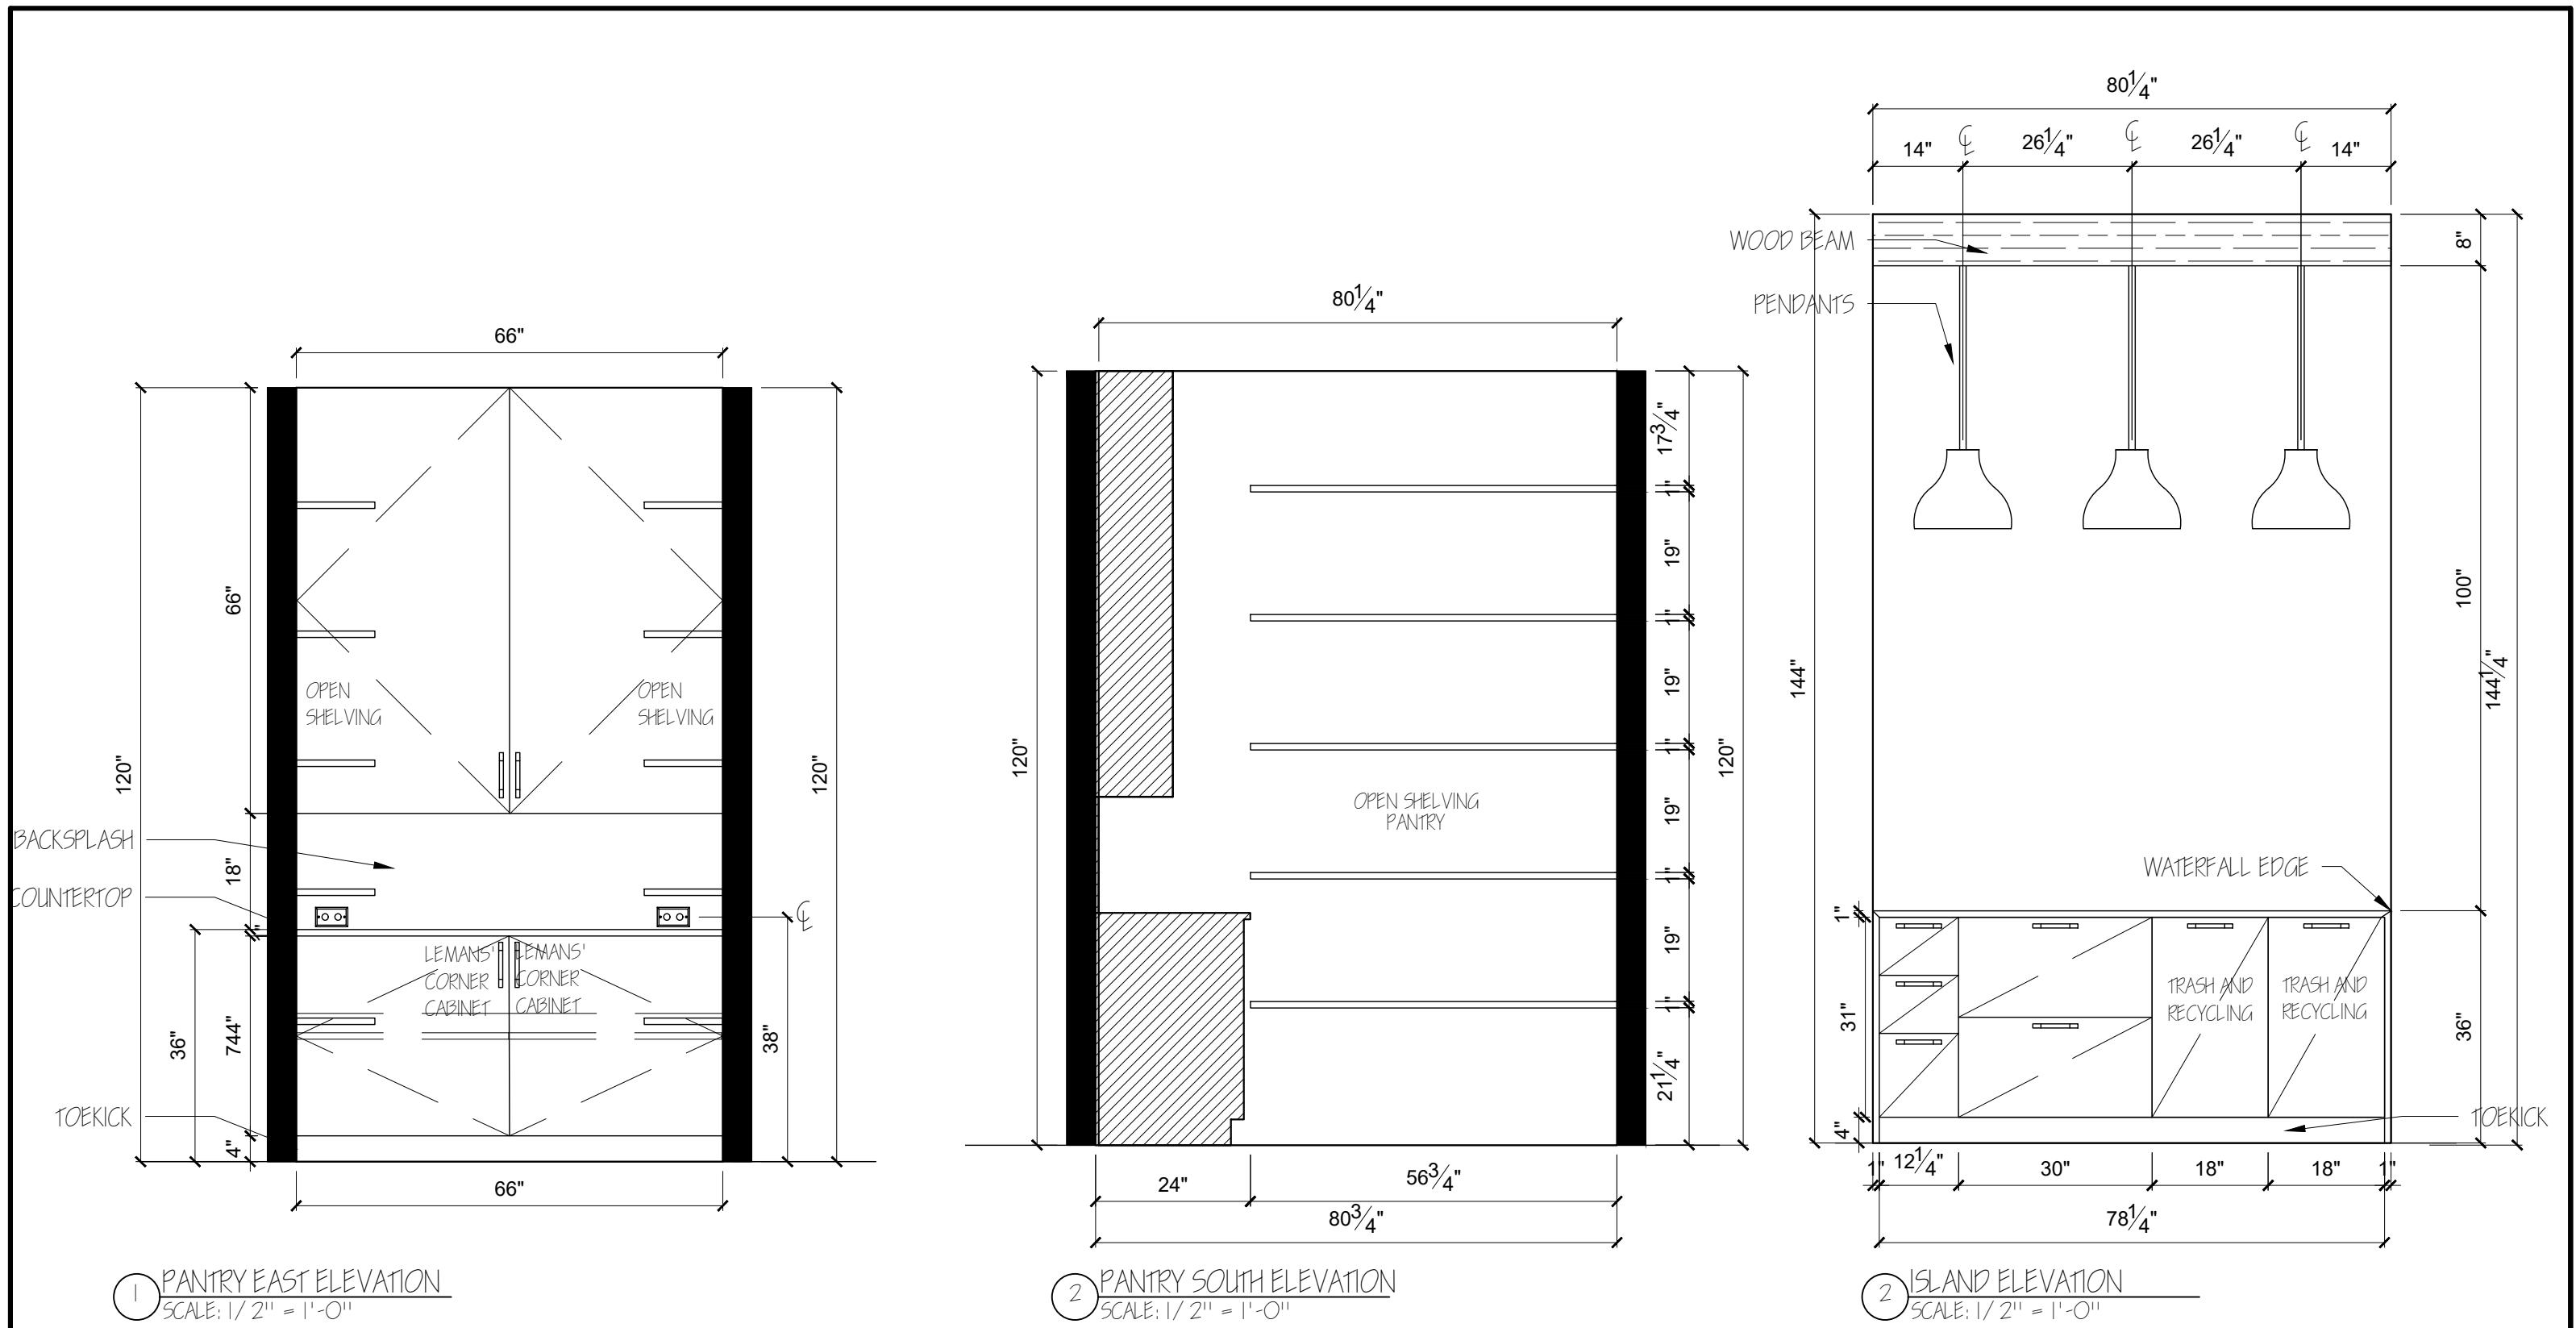

ALL DIMENSIONS AND SIZE
DESIGNATIONS GIVEN ARE
SUBJECT TO VERIFICATION
ON JOB SITE & ADJUSTMENT
TO FIT JOB CONDITIONS

NKBA *The Finest
Professionals
in the Kitchen
& Bath Industry*
National Kitchen & Bath AssociationSM

DESIGN PLANS ARE PROVIDED FOR THE FAIR USE BY THE
CLIENT OR HIS AGENT IN COMPLETING THE PROJECT AS
LISTED WITHIN THIS CONTRACT. DESIGN PLANS REMAIN
THE PROPERTY OF THIS FIRM AND CAN NOT BE USED OR
REUSED WITHOUT PERMISSION.

DESIGNED FOR
NKBA COMPETITION

BY
K4056555917

DATE	BY	SCALE	DWG NO
09022021	DWN	1/2" =	A5
	REV	1'0"	